

HOSPITAL CORPORATION OF AMERICA (HCA) 2545 PARK PLAZA, BUILDING 3-2 NASHVILLE, TN 37203

FACILITY RIVERSIDE COMMUNITY HOSPITAL 4445 MAGNOLIA AVENUE

ARCHITECT/ **INTERIOR DESIGNER**

HKS ARCHITECTS, INC. 10880 WILSHIRE BLVD, #1850

CIVIL ENGINEER/ LANDSCAPE ARCHITECT

KIMLEY-HORN AND ASSOCIATES, INC. 1100 W. TOWN & COUNTRY ROAD, SUITE 700

ORANGE, CA 92868 STRUCTURAL ENGINEER

700 S FLOWER STREET, SUITE 2100

LOS ANGELES, CA 90017

MEP/LOW VOLTAGE ENGINEER

3102 OAK LAWN AVE, SUITE 450

DALLAS, TX 75219

PARKING CONSULTANT HWA PARKING

AUSTIN, TX 78759


HCA DESIGN MANAGER ZACH WIDEMAN

HCA CONSTRUCTION MANAGER



NEW BROCKTON PARKING GARAGE



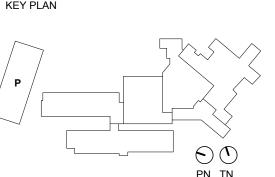

REVISION
NO. DESCRIPTION


HKS PROJECT NUMBER 26153.100

HCA PROJECT NUMBER 0715000049

11/08/2024 PLANNING SUBMITTAL

SHEET TITLE **PLOT PLAN SECTIONS**

C1.1

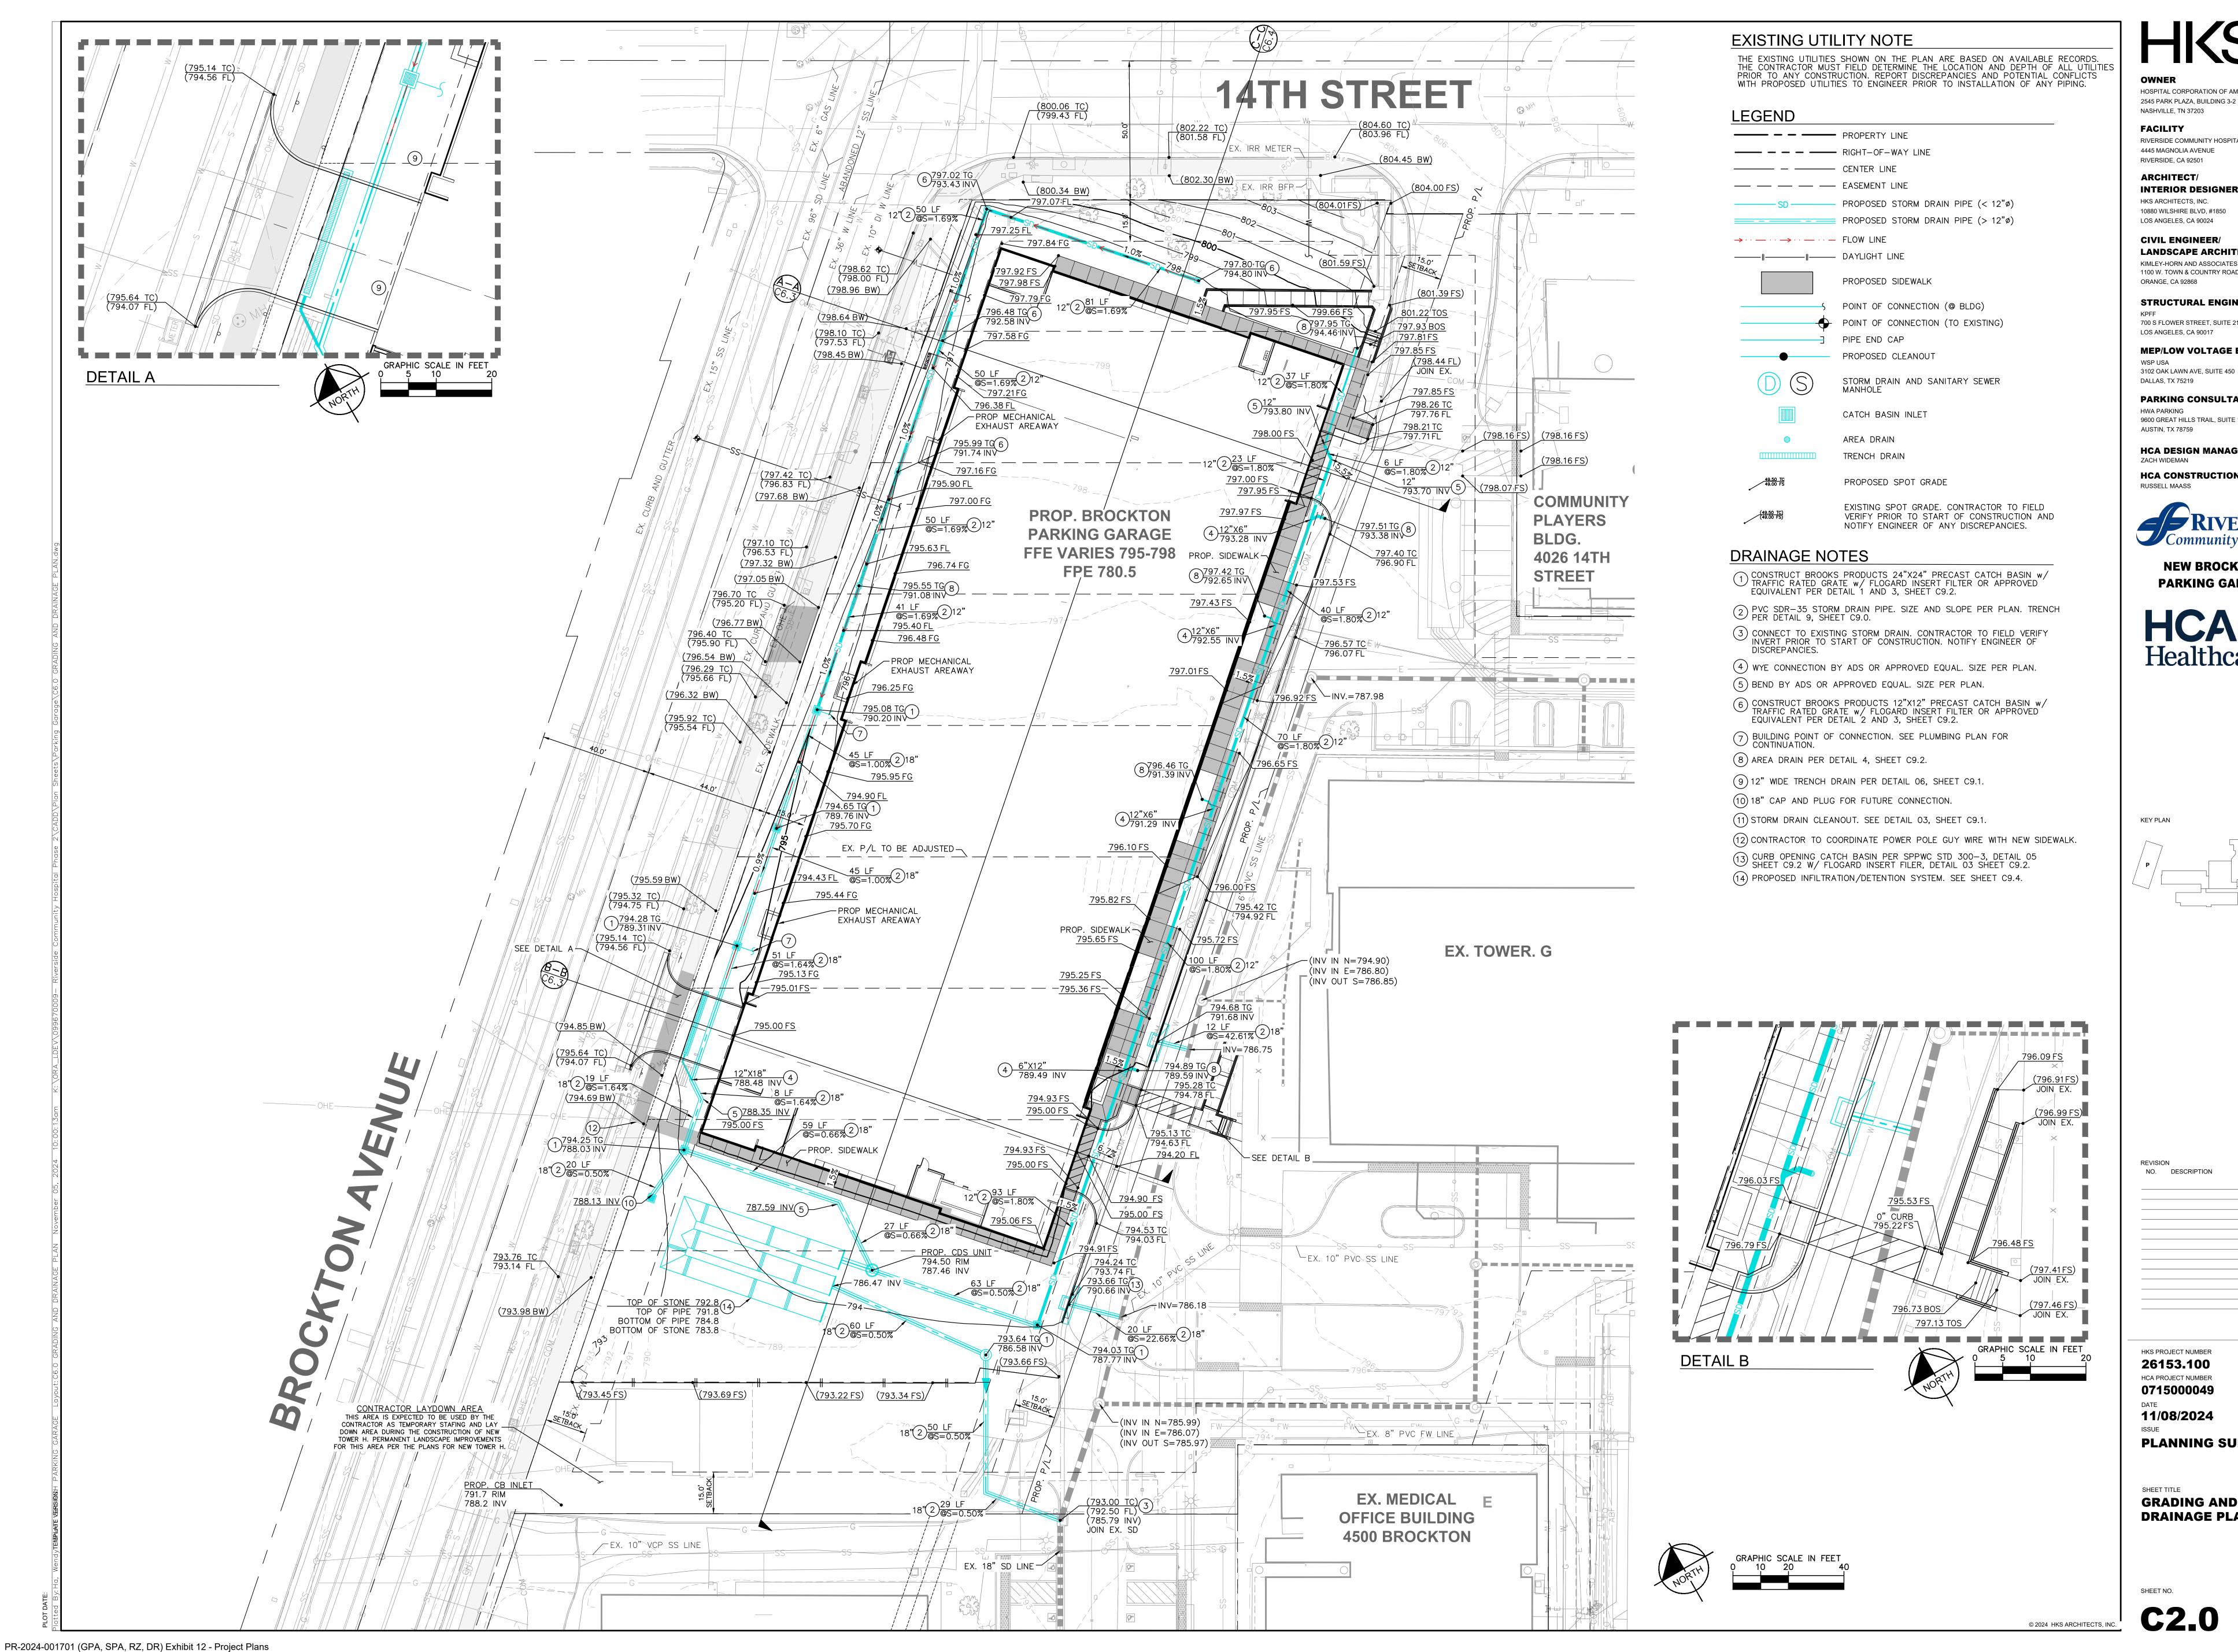

HOSPITAL CORPORATION OF AMERICA (HCA) 2545 PARK PLAZA, BUILDING 3-2

NASHVILLE, TN 37203 **FACILITY**

RIVERSIDE COMMUNITY HOSPITAL 4445 MAGNOLIA AVENUE RIVERSIDE, CA 92501

ARCHITECT/ **INTERIOR DESIGNER**

HKS ARCHITECTS, INC. 10880 WILSHIRE BLVD, #1850 LOS ANGELES, CA 90024

LANDSCAPE ARCHITECT KIMLEY-HORN AND ASSOCIATES, INC. 1100 W. TOWN & COUNTRY ROAD, SUITE 700 ORANGE, CA 92868

STRUCTURAL ENGINEER

700 S FLOWER STREET, SUITE 2100 LOS ANGELES, CA 90017

MEP/LOW VOLTAGE ENGINEER

DALLAS, TX 75219 **PARKING CONSULTANT** HWA PARKING


9600 GREAT HILLS TRAIL, SUITE 150W AUSTIN, TX 78759 **HCA DESIGN MANAGER**

HCA CONSTRUCTION MANAGER RUSSELL MAASS

RIVERSIDE **Community Hospital**

NEW BROCKTON PARKING GARAGE



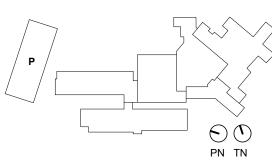

NO. DESCRIPTION


HKS PROJECT NUMBER 26153.100 HCA PROJECT NUMBER 0715000049

11/08/2024

PLANNING SUBMITTAL

SHEET TITLE **GRADING AND DRAINAGE PLAN**

SHEET NO.

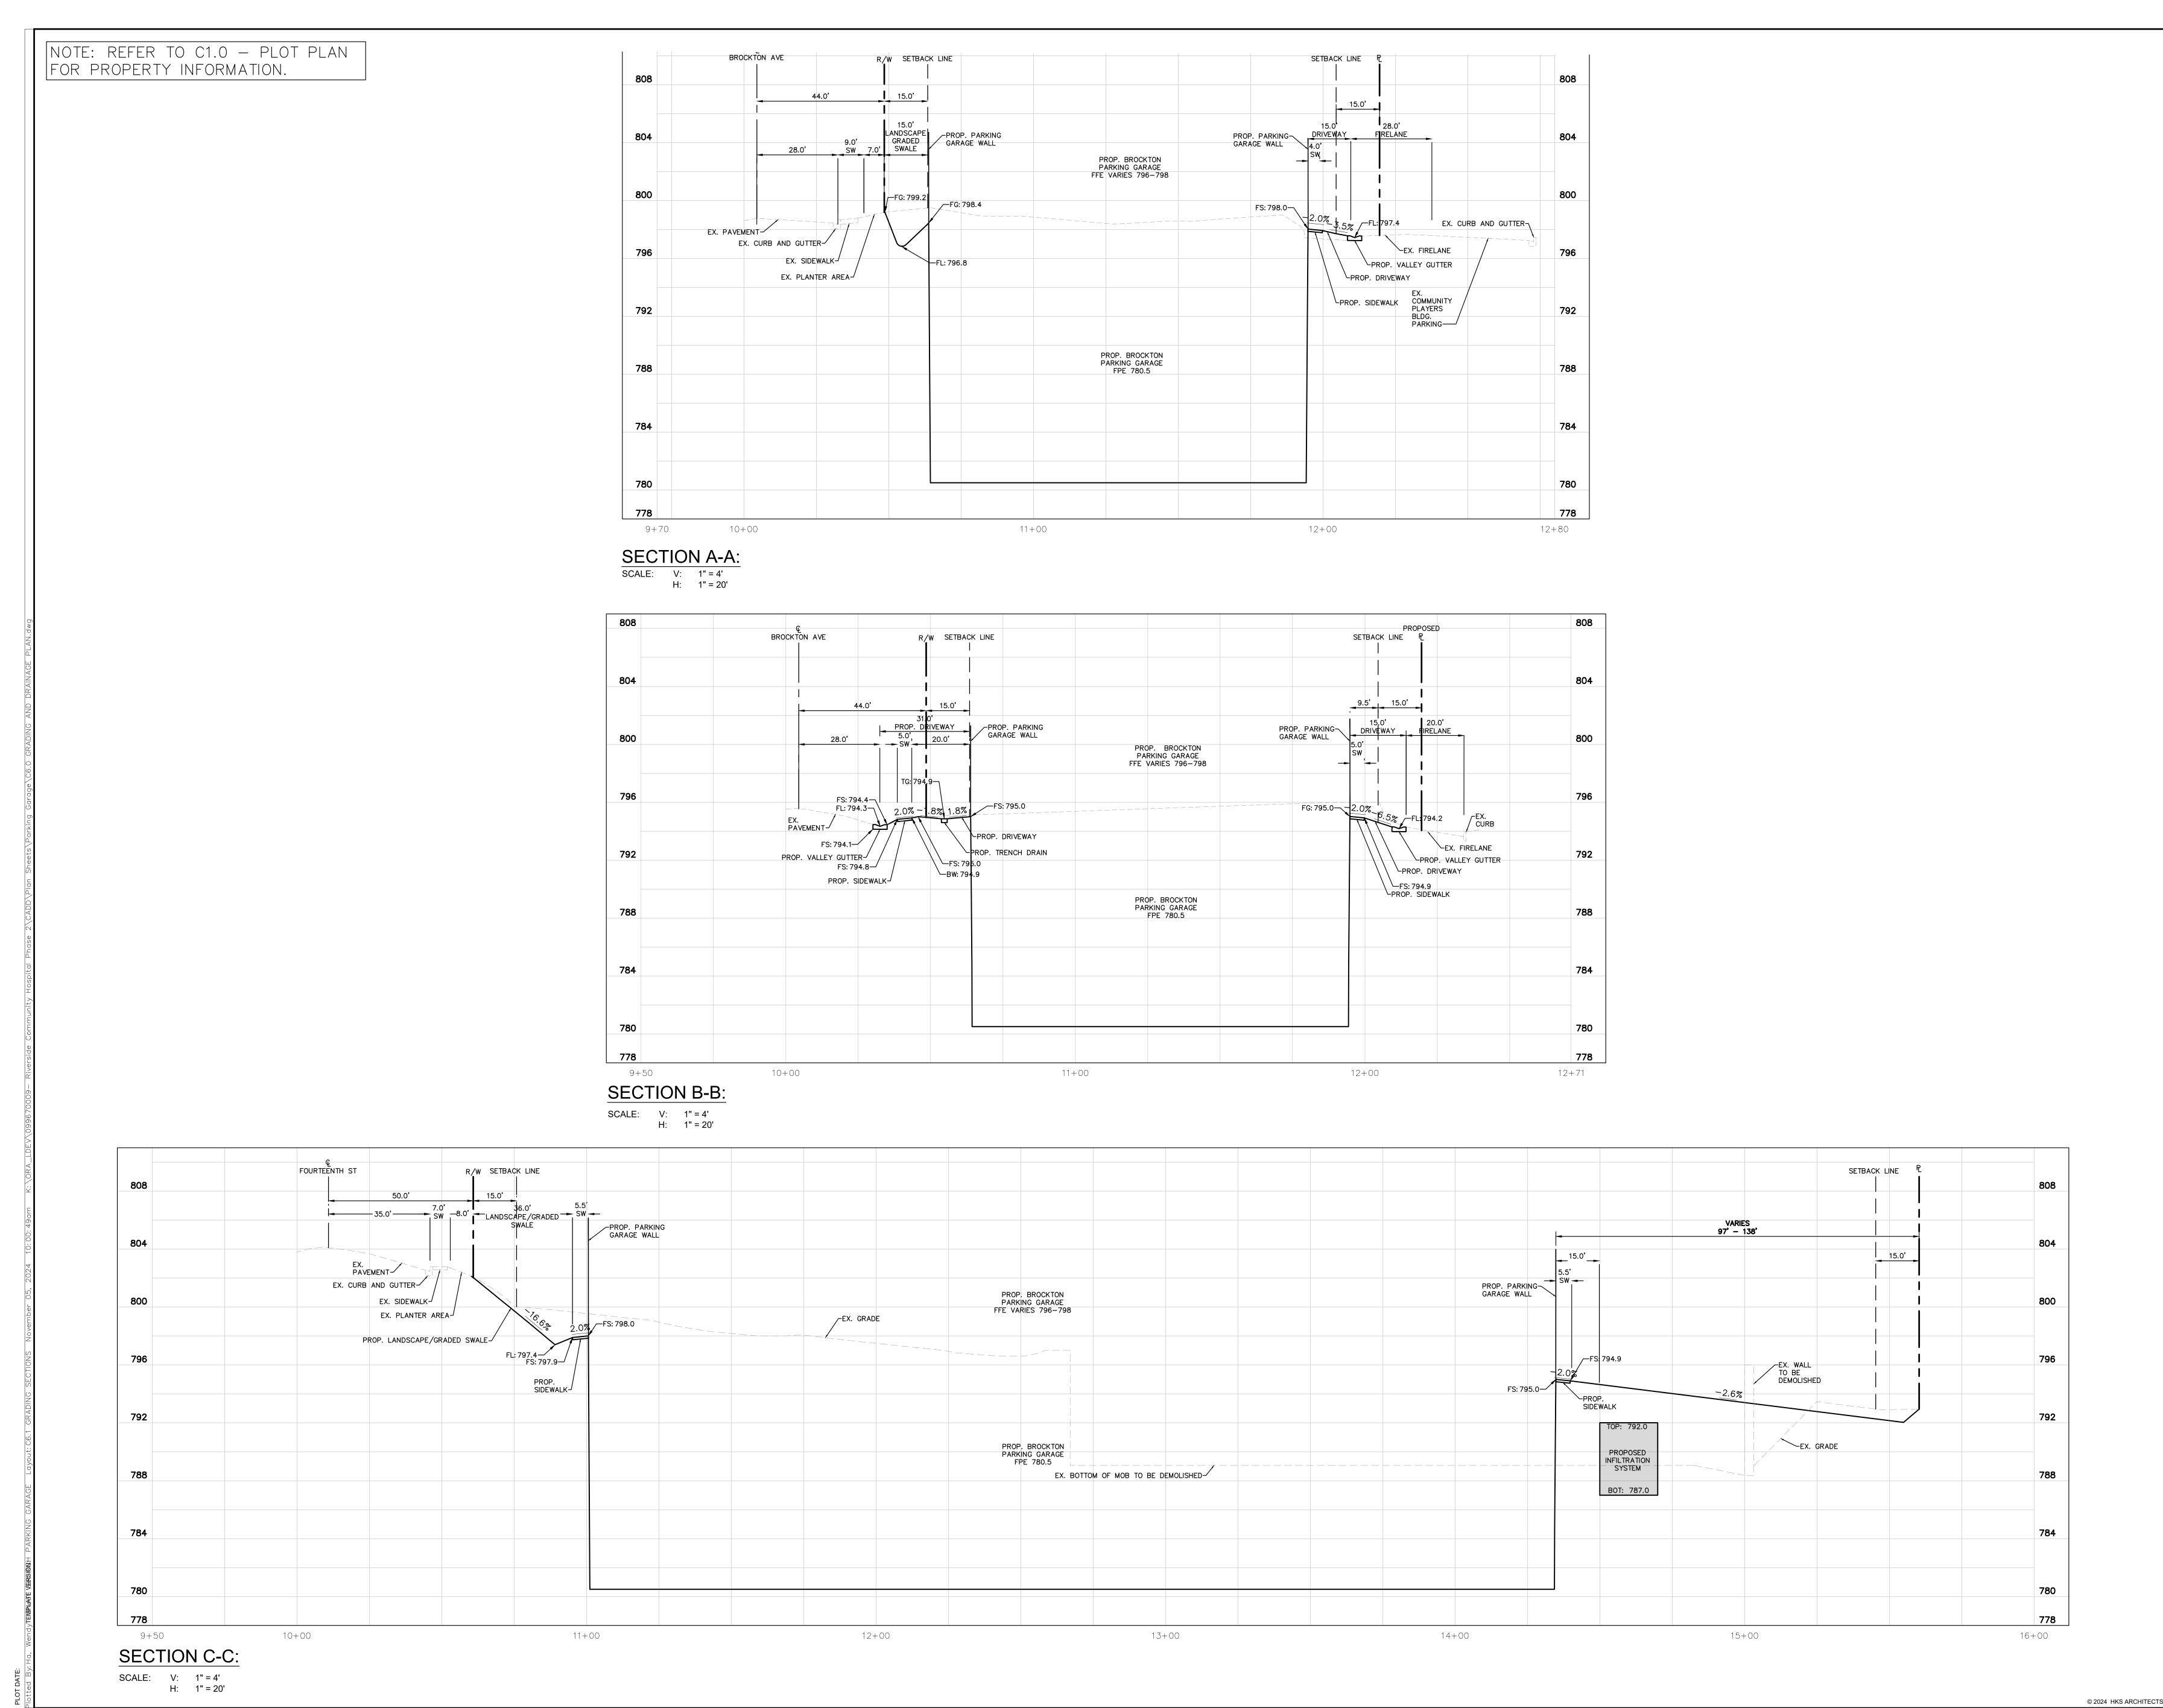

H(S

OWNER

HOSPITAL CORPORATION OF AMERICA (HCA) 2545 PARK PLAZA, BUILDING 3-2 NASHVILLE, TN 37203

FACILITY
RIVERSIDE COMMUNITY HOSPITAL
4445 MAGNOLIA AVENUE

ARCHITECT/ INTERIOR DESIGNER

RIVERSIDE, CA 92501

HKS ARCHITECTS, INC.
10880 WILSHIRE BLVD, #1850

LOS ANGELES, CA 90024

CIVIL ENGINEER/

LANDSCAPE ARCHITECT
KIMLEY-HORN AND ASSOCIATES, INC.
1100 W. TOWN & COUNTRY ROAD, SUITE 700

STRUCTURAL ENGINEER

700 S FLOWER STREET, SUITE 2100 LOS ANGELES, CA 90017

ORANGE, CA 92868

DALLAS, TX 75219

RUSSELL MAASS

MEP/LOW VOLTAGE ENGINEER

WSP USA 3102 OAK LAWN AVE, SUITE 450

PARKING CONSULTANT
HWA PARKING

9600 GREAT HILLS TRAIL, SUITE 150W AUSTIN, TX 78759

HCA DESIGN MANAGER
ZACH WIDEMAN


RIVERSIDE Community Hospital

HCA CONSTRUCTION MANAGER

NEW BROCKTON
PARKING GARAGE



KEY PLAN

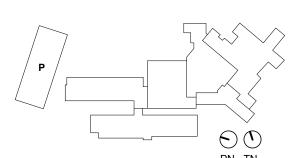

REVISION NO. DESCRIPTION DATE

HKS PROJECT NUMBER
26153.100
HCA PROJECT NUMBER

0715000049 DATE 11/08/2024


ISSUE PLANNING SUBMITTAL

SHEET TITLE

GRADING


SECTIONS

SHEET NO.

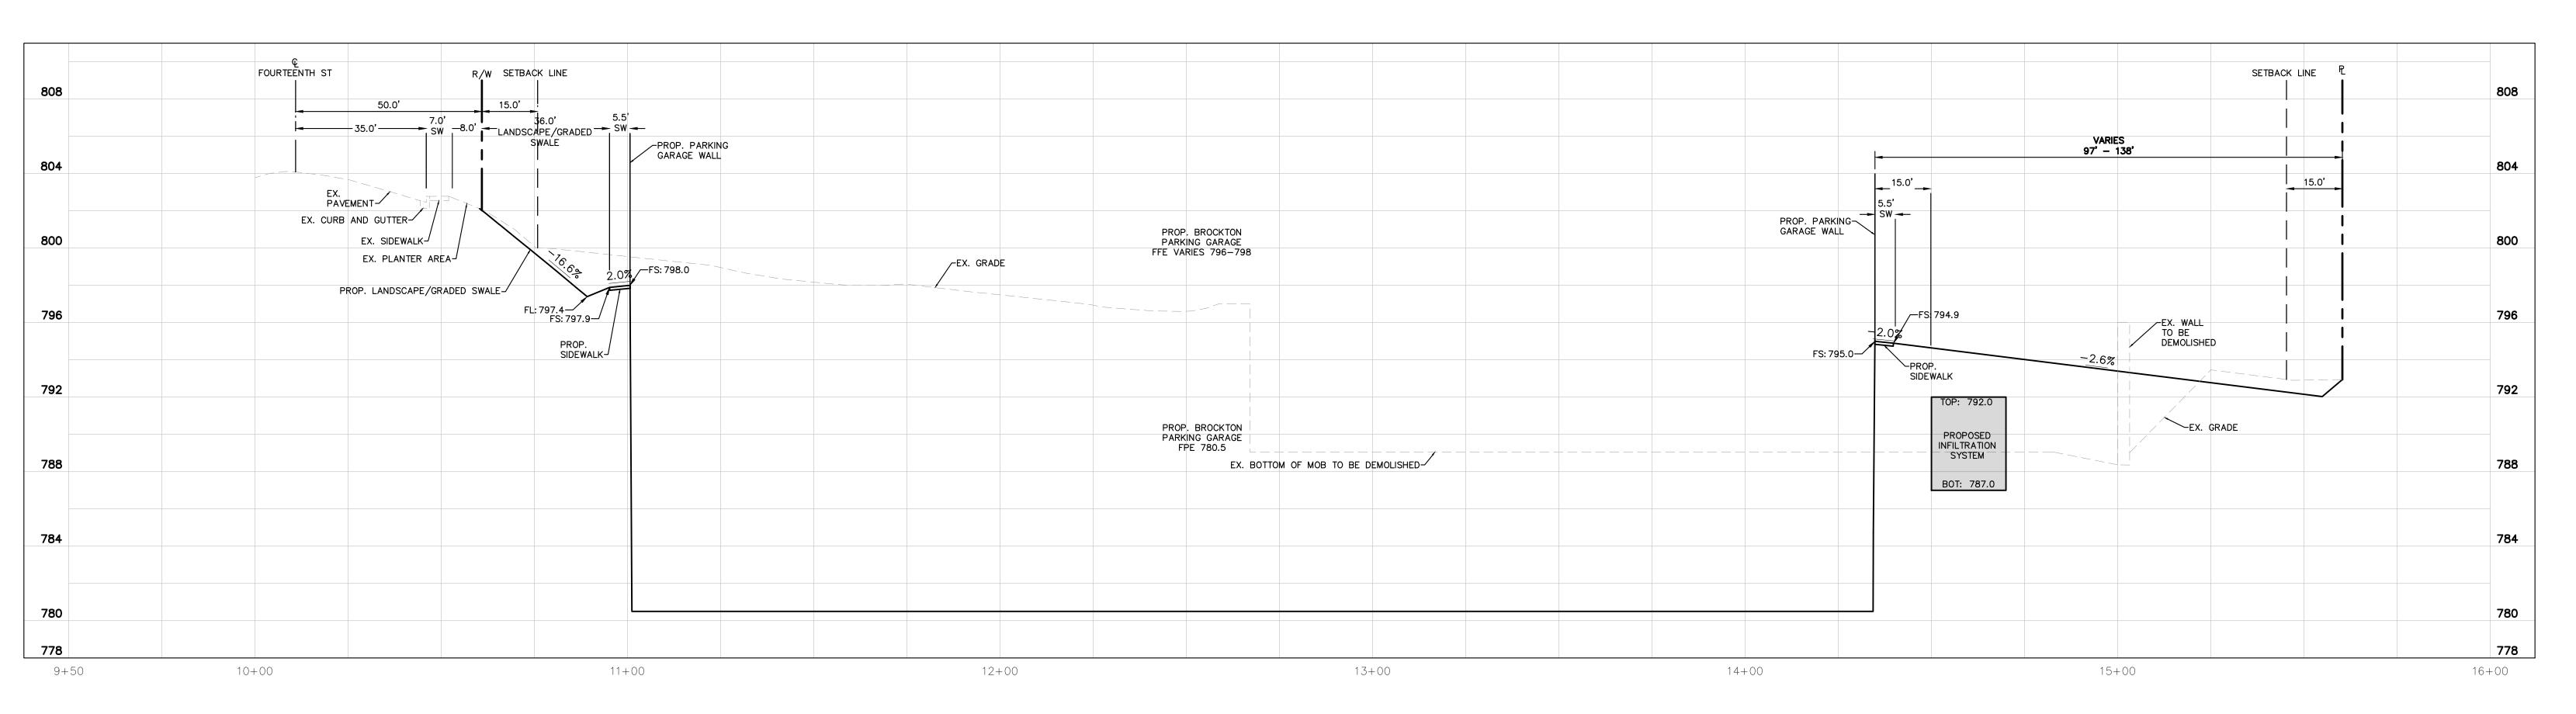

SECTION C-C:

SCALE: V: 1" = 4'
H: 1" = 20'

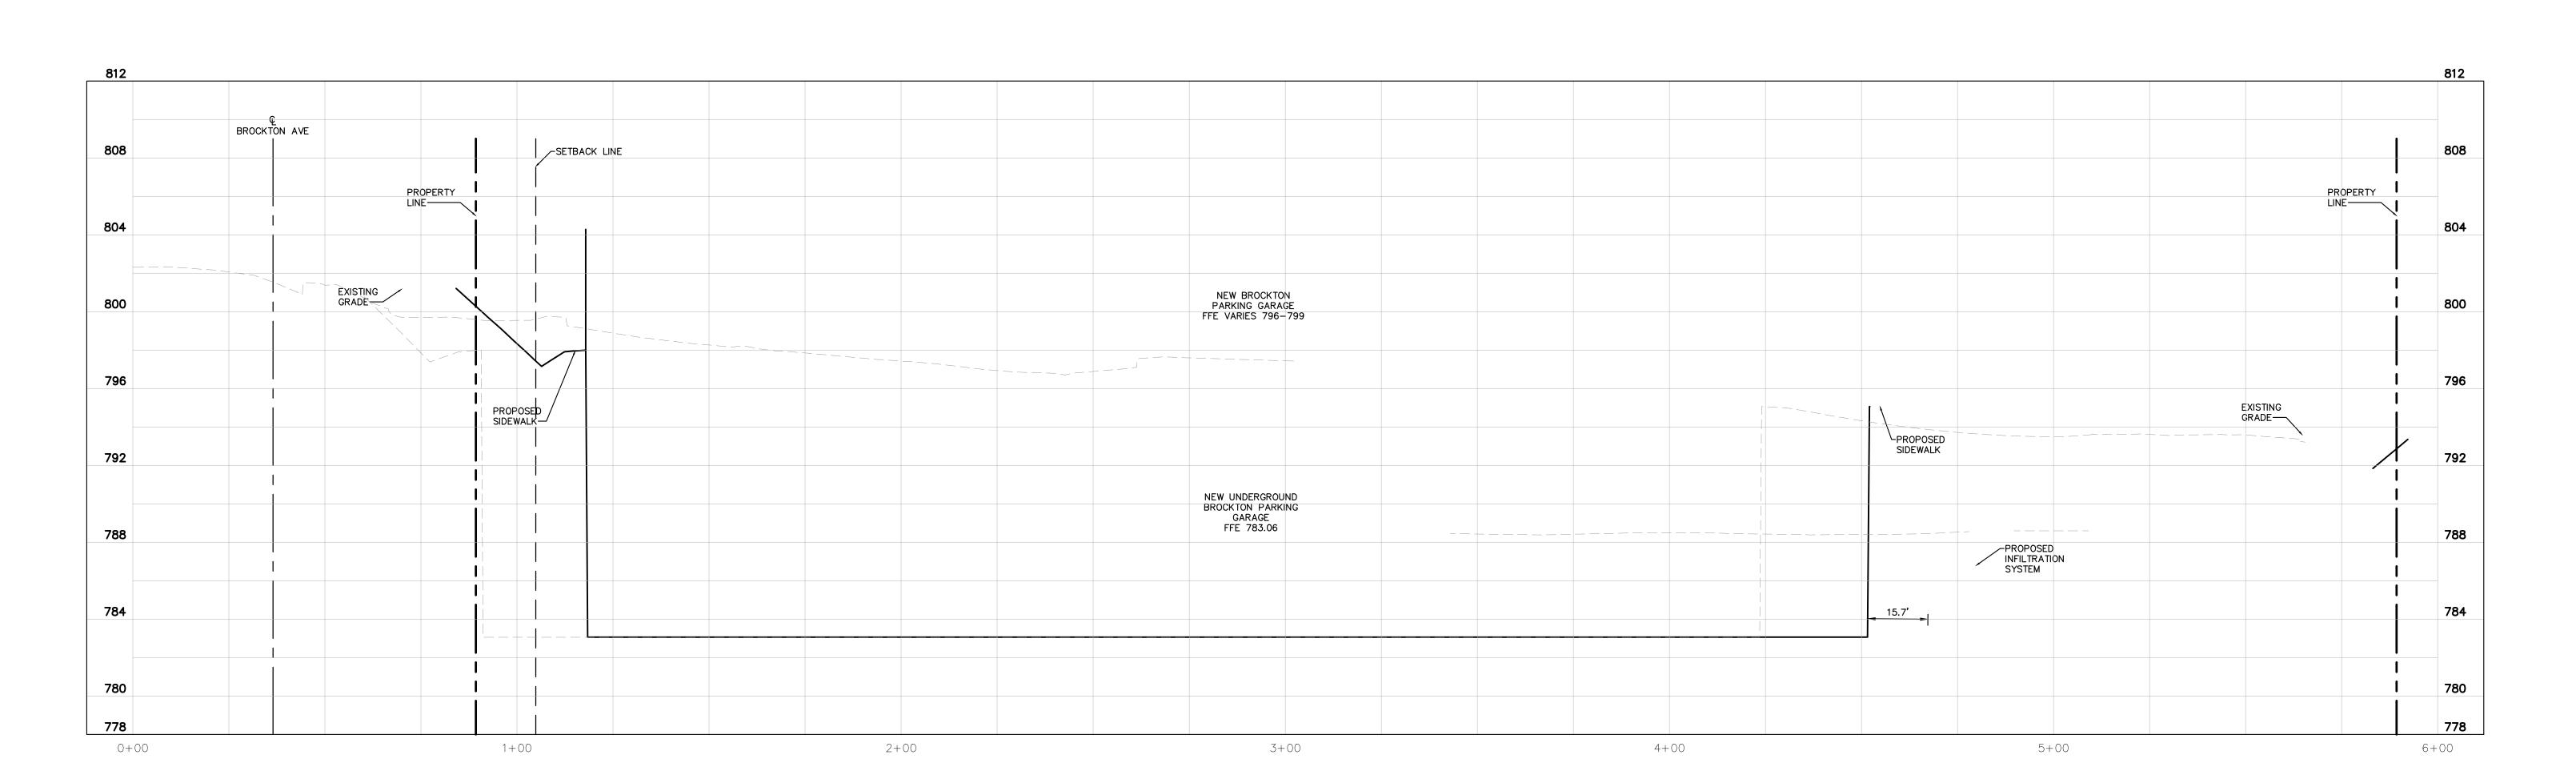

SECTION D-D:

SCALE: V: 1" = 4'
H: 1" = 20'

HKS

OWNER
HOSPITAL CORPORATION OF AMERICA (HCA)

2545 PARK PLAZA, BUILDING 3-2
NASHVILLE, TN 37203

FACILITY
RIVERSIDE COMMUNITY HOSPITAL

4445 MAGNOLIA AVENUE
RIVERSIDE, CA 92501

ARCHITECT/
INTERIOR DESIGNER

HKS ARCHITECTS, INC. 10880 WILSHIRE BLVD, #1850 LOS ANGELES, CA 90024

CIVIL ENGINEER/
LANDSCAPE ARCHITECT

KIMLEY-HORN AND ASSOCIATES, INC.
1100 W. TOWN & COUNTRY ROAD, SUITE 700

ORANGE, CA 92868

STRUCTURAL ENGINEER

KPFF 700 S FLOWER STREET, SUITE 2100 LOS ANGELES, CA 90017

MEP/LOW VOLTAGE ENGINEER

WSP USA 3102 OAK LAWN AVE, SUITE 450 DALLAS, TX 75219

PARKING CONSULTANT
HWA PARKING
9600 GREAT HILLS TRAIL, SUITE 150W

9600 GREAT HILLS TRAIL, SUITE 150W AUSTIN, TX 78759 HCA DESIGN MANAGER


ZACH WIDEMAN

HCA CONSTRUCTION MANAGER
RUSSELL MAASS

RIVERSIDE Community Hospital NEW BROCKTON



KEY PLAN

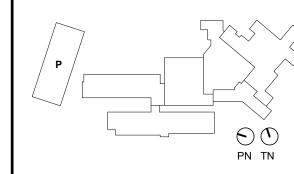

REVISION

NO. DESCRIPTION I

HKS PROJECT NUMBER
26153.100
HCA PROJECT NUMBER
0715000049


DATE 11/08/2024

PLANNING SUBMITTAL

SHEET TITLE

GRADING
SECTIONS

SHEET NO. **C2.2**

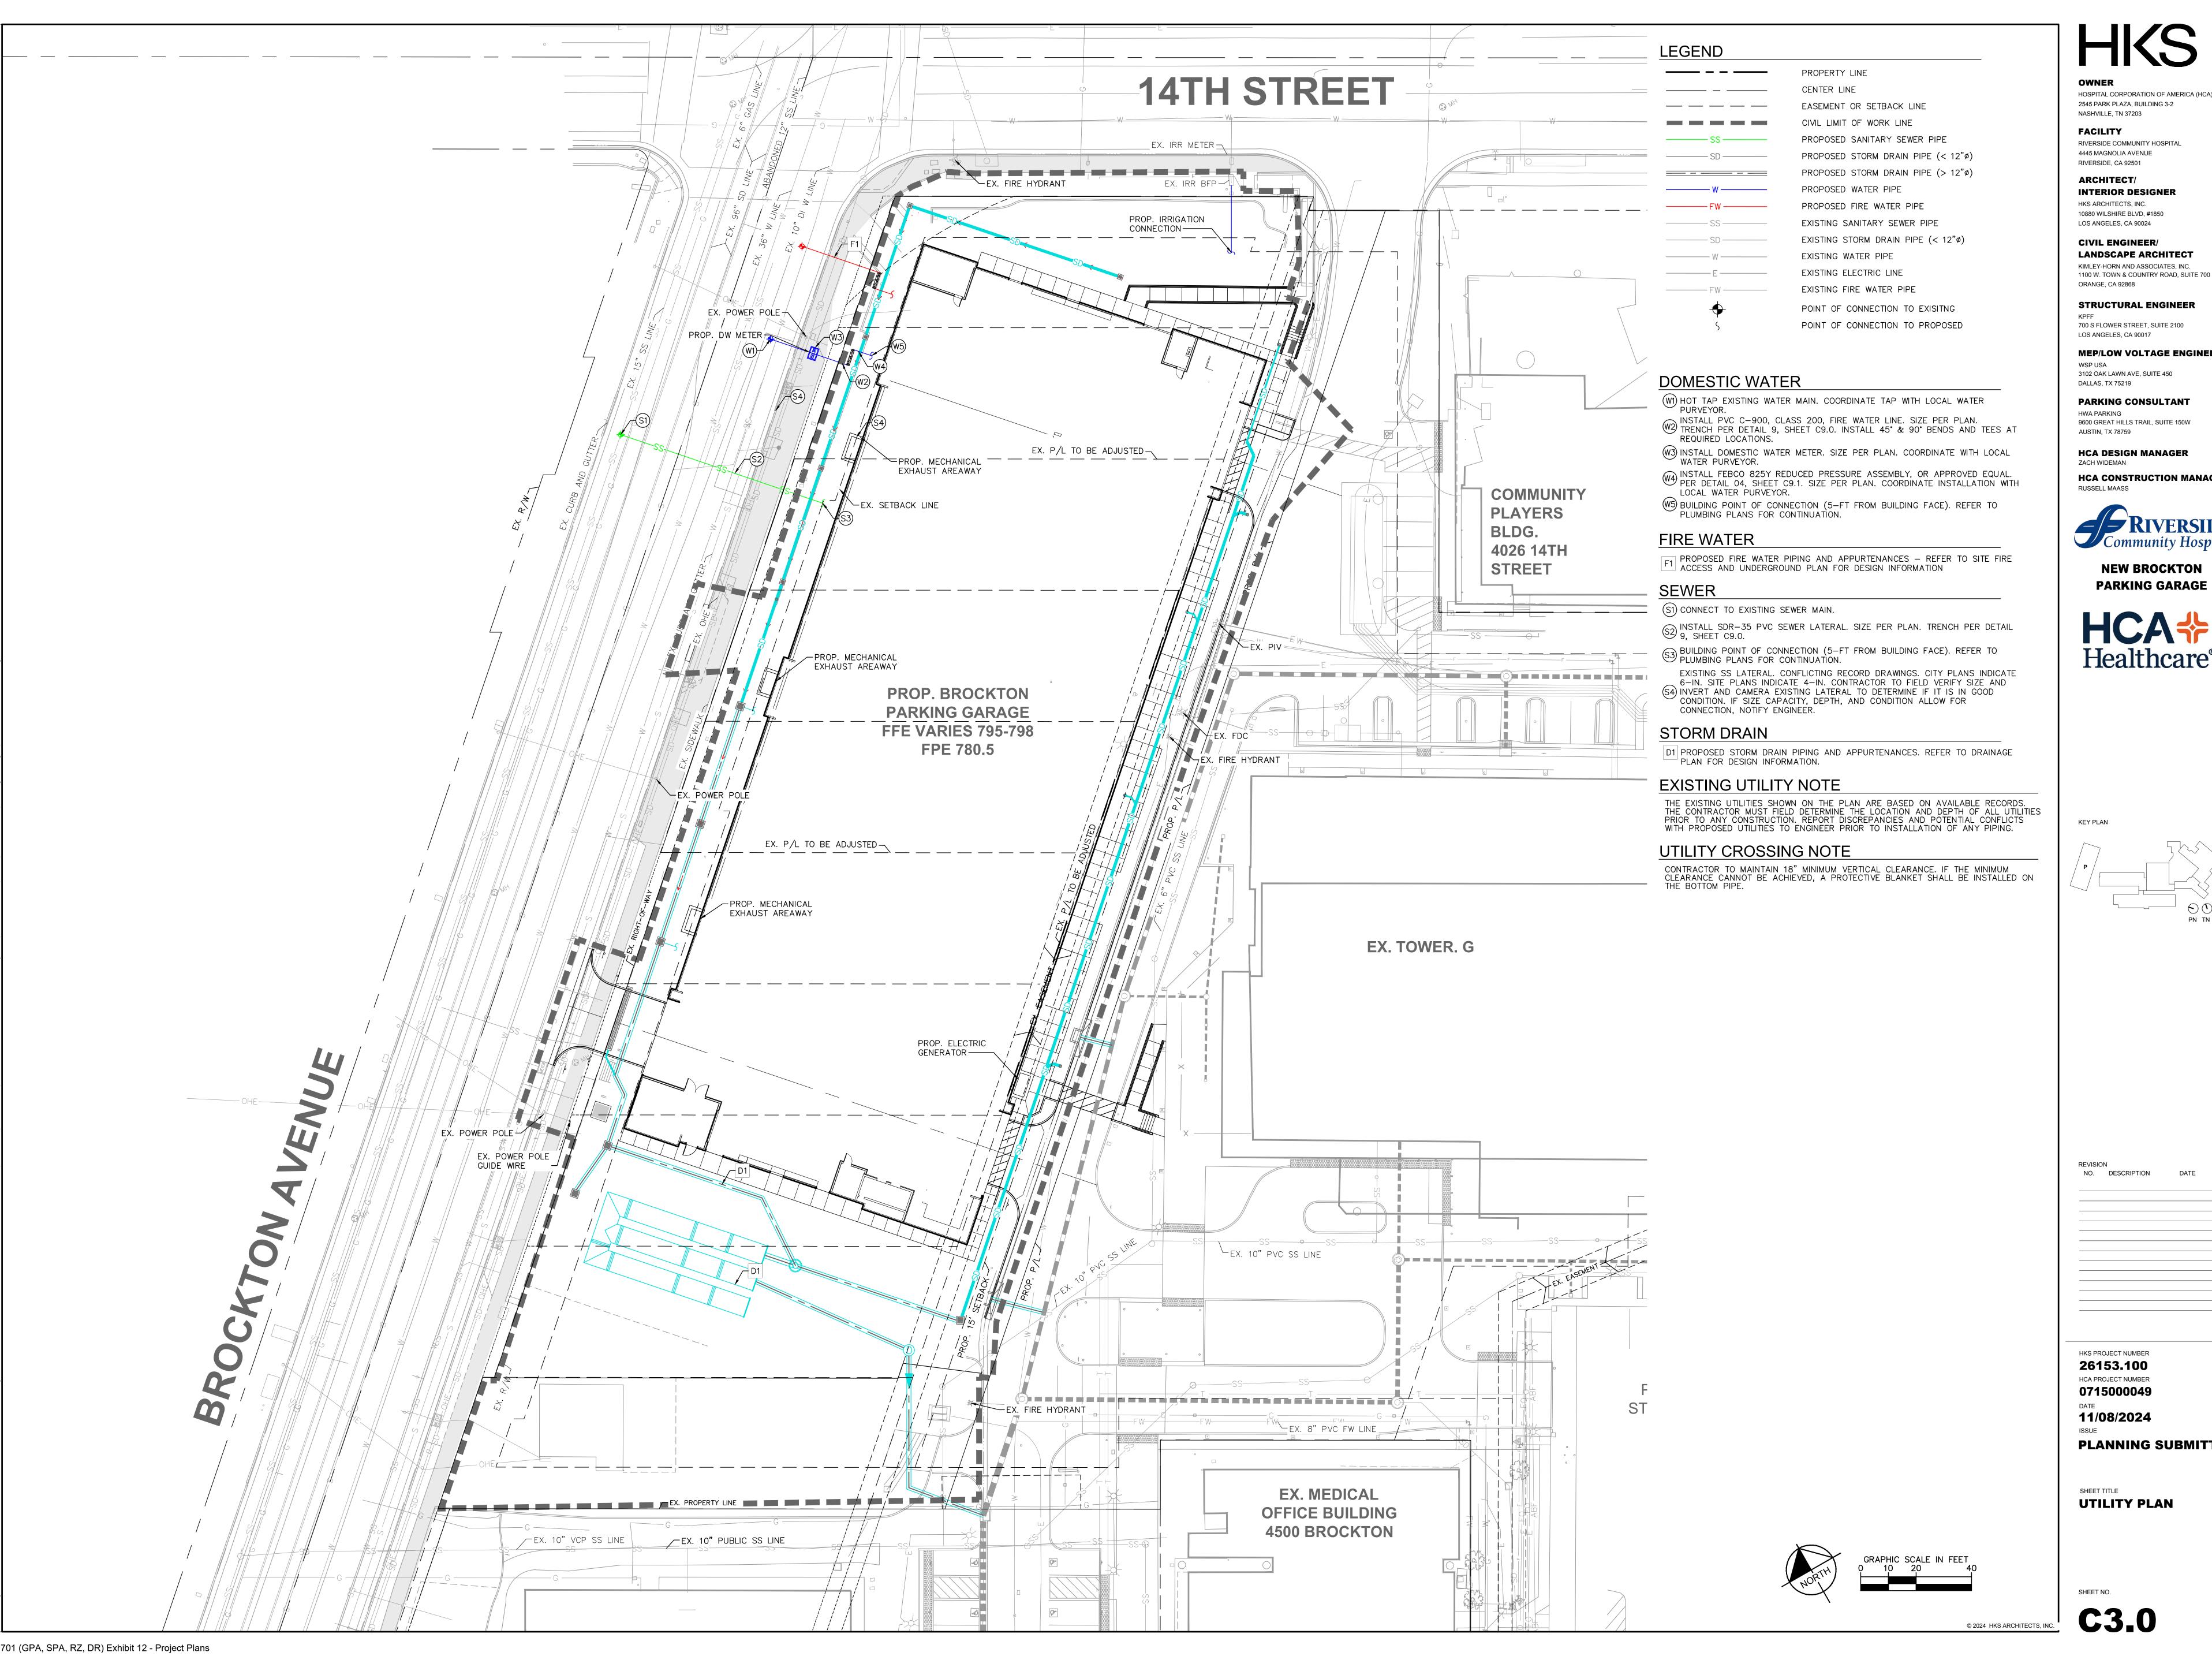

HOSPITAL CORPORATION OF AMERICA (HCA) 2545 PARK PLAZA, BUILDING 3-2 NASHVILLE, TN 37203

FACILITY

RIVERSIDE COMMUNITY HOSPITAL 4445 MAGNOLIA AVENUE

ARCHITECT/ INTERIOR DESIGNER

HKS ARCHITECTS, INC. 10880 WILSHIRE BLVD, #1850 LOS ANGELES, CA 90024

CIVIL ENGINEER/ LANDSCAPE ARCHITECT

ORANGE, CA 92868 STRUCTURAL ENGINEER

700 S FLOWER STREET, SUITE 2100

LOS ANGELES, CA 90017

MEP/LOW VOLTAGE ENGINEER 3102 OAK LAWN AVE, SUITE 450

PARKING CONSULTANT

HWA PARKING 9600 GREAT HILLS TRAIL, SUITE 150W AUSTIN, TX 78759


HCA DESIGN MANAGER

HCA CONSTRUCTION MANAGER RUSSELL MAASS

RIVERSIDE Community Hospital

NEW BROCKTON PARKING GARAGE



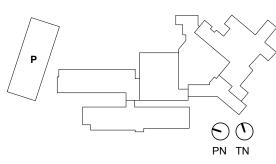

NO. DESCRIPTION

HKS PROJECT NUMBER

26153.100 HCA PROJECT NUMBER 0715000049

11/08/2024

PLANNING SUBMITTAL

UTILITY PLAN