

009 mos

Architecture


www.VisioneeringStudios.com


PROJECT

CODE


LAN & PARKING ANALYSIS R SITE PLAN - FULL BUILDOUT


Sheet No.

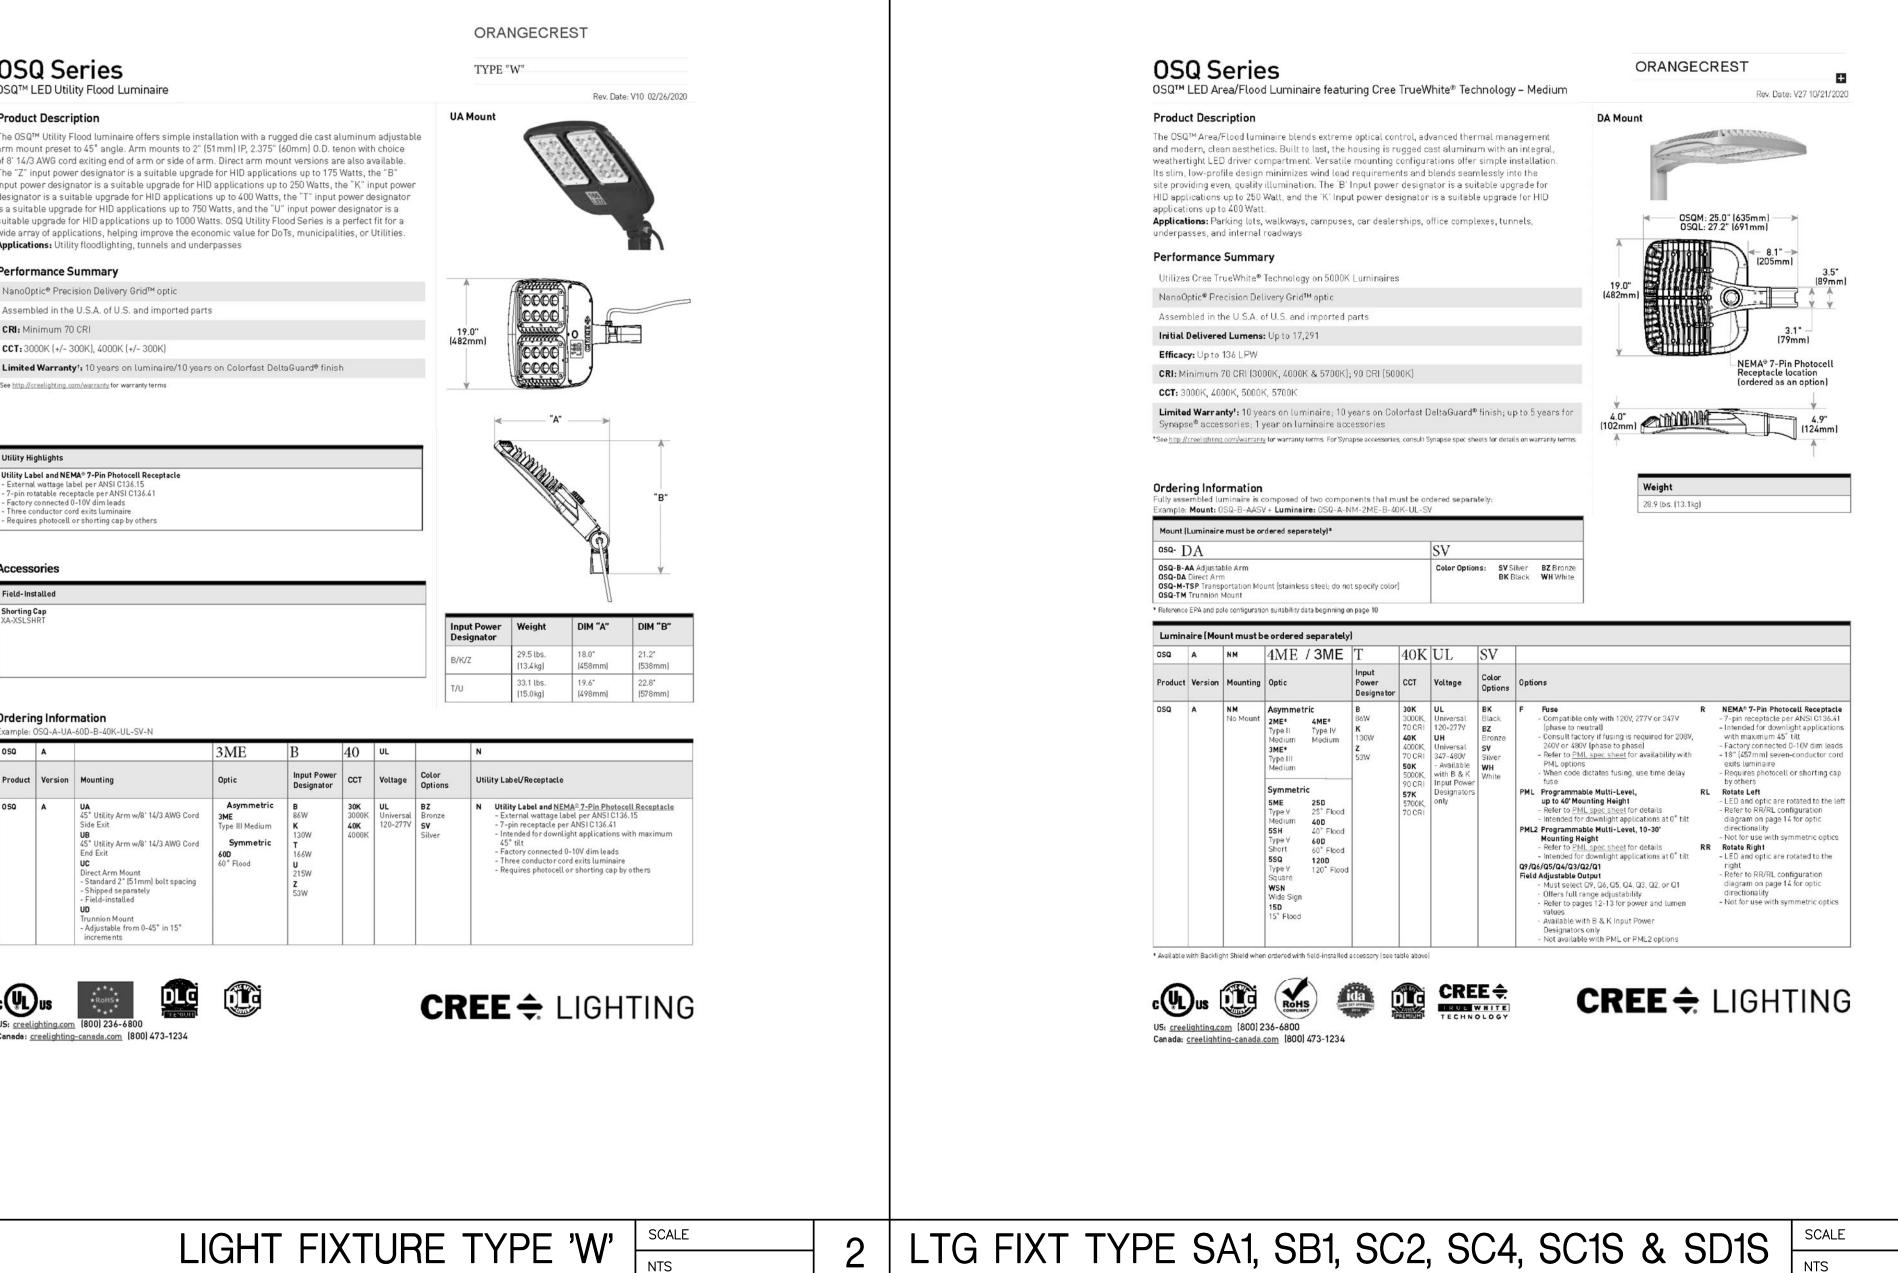


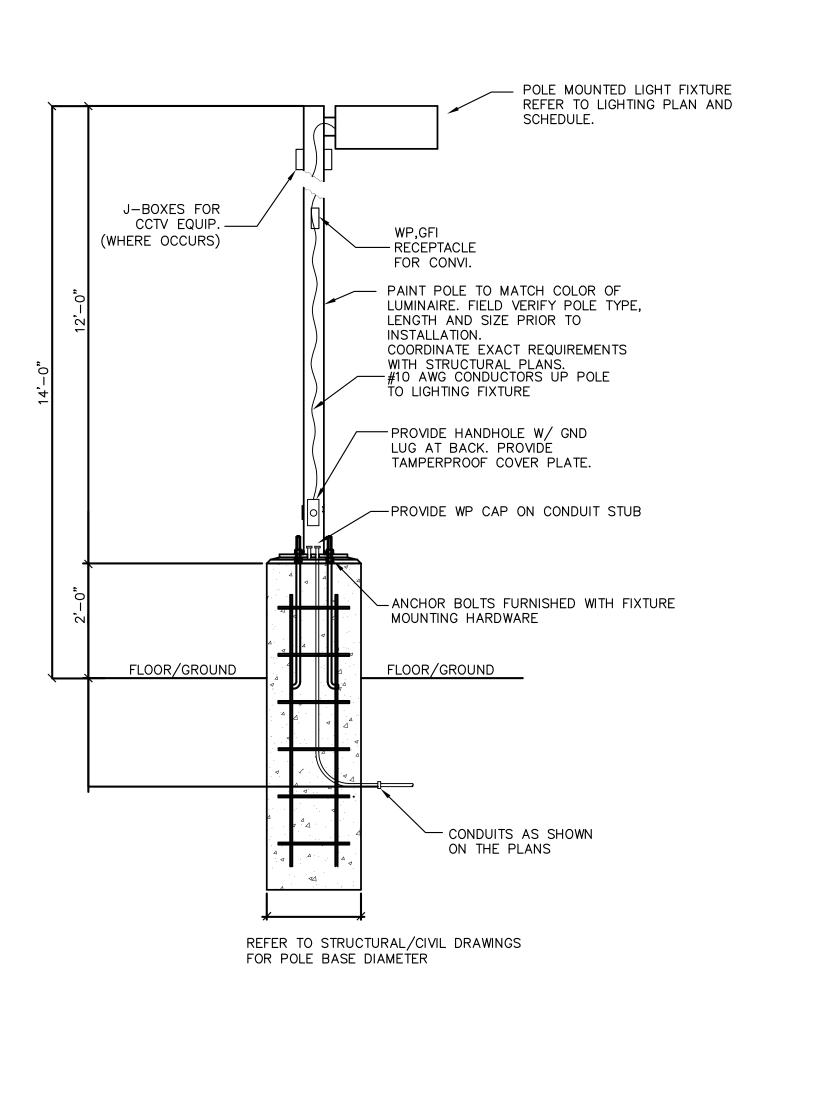


14' POLE & BASE DETAIL (TYPE SC1S & SD1S) | SCALE | NTS

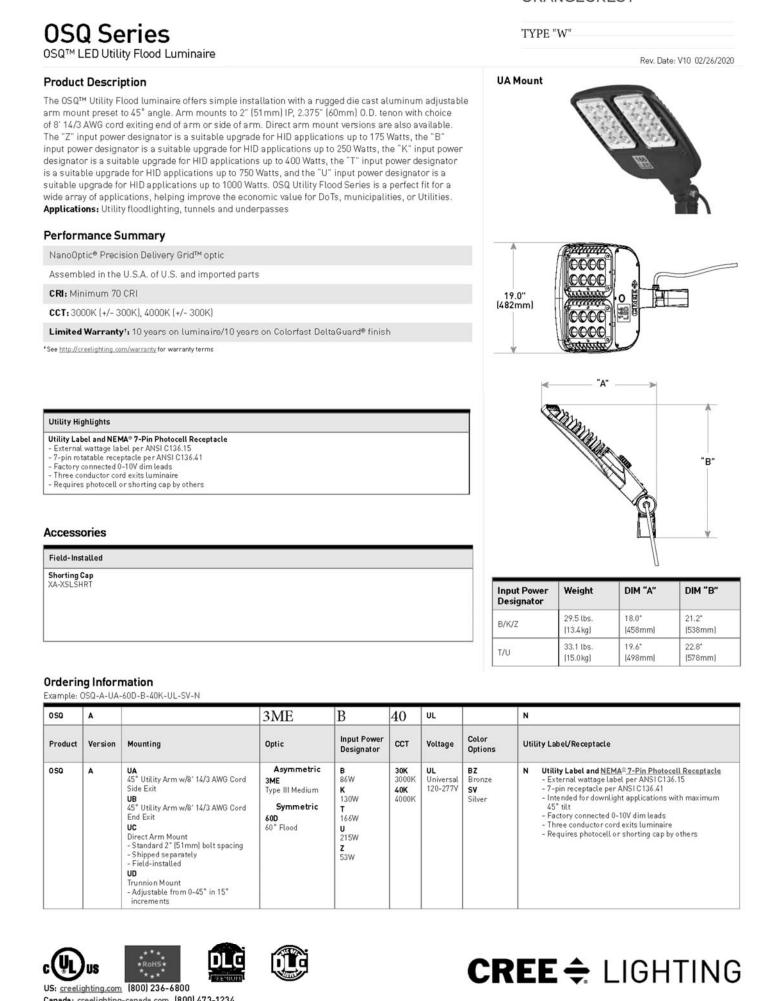

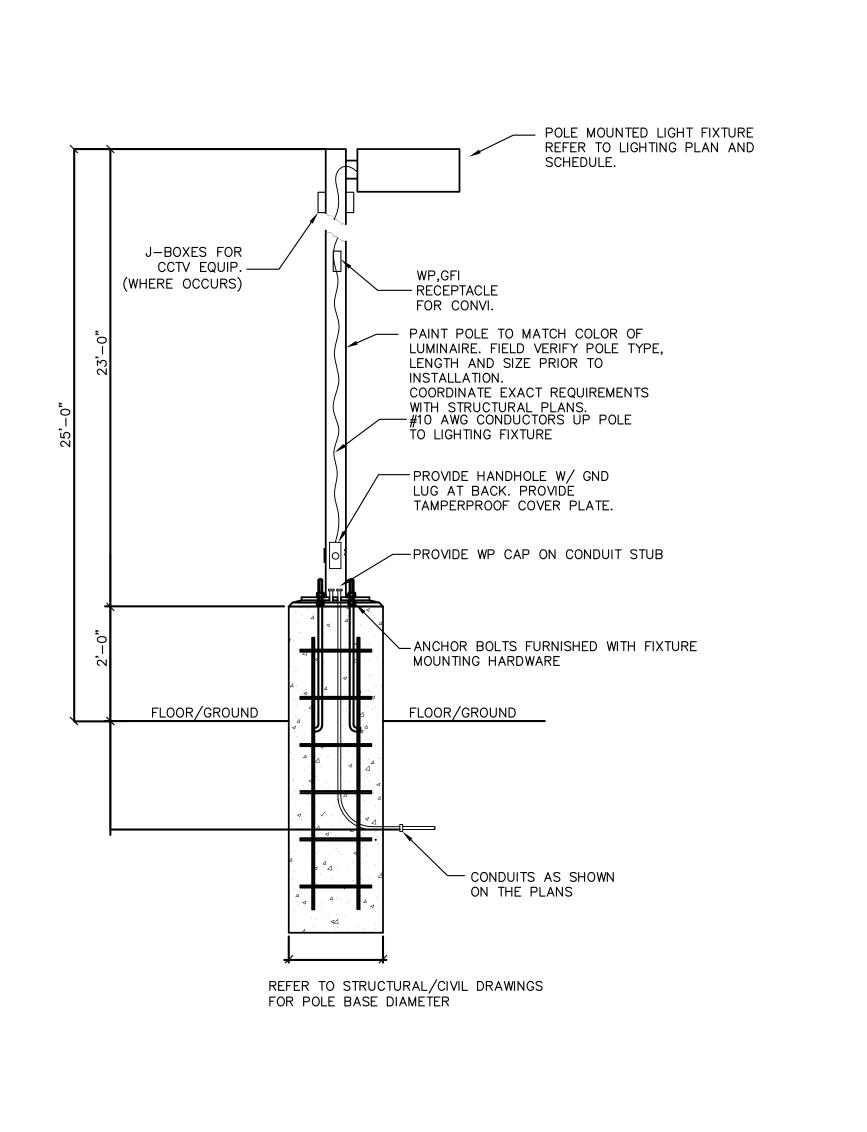

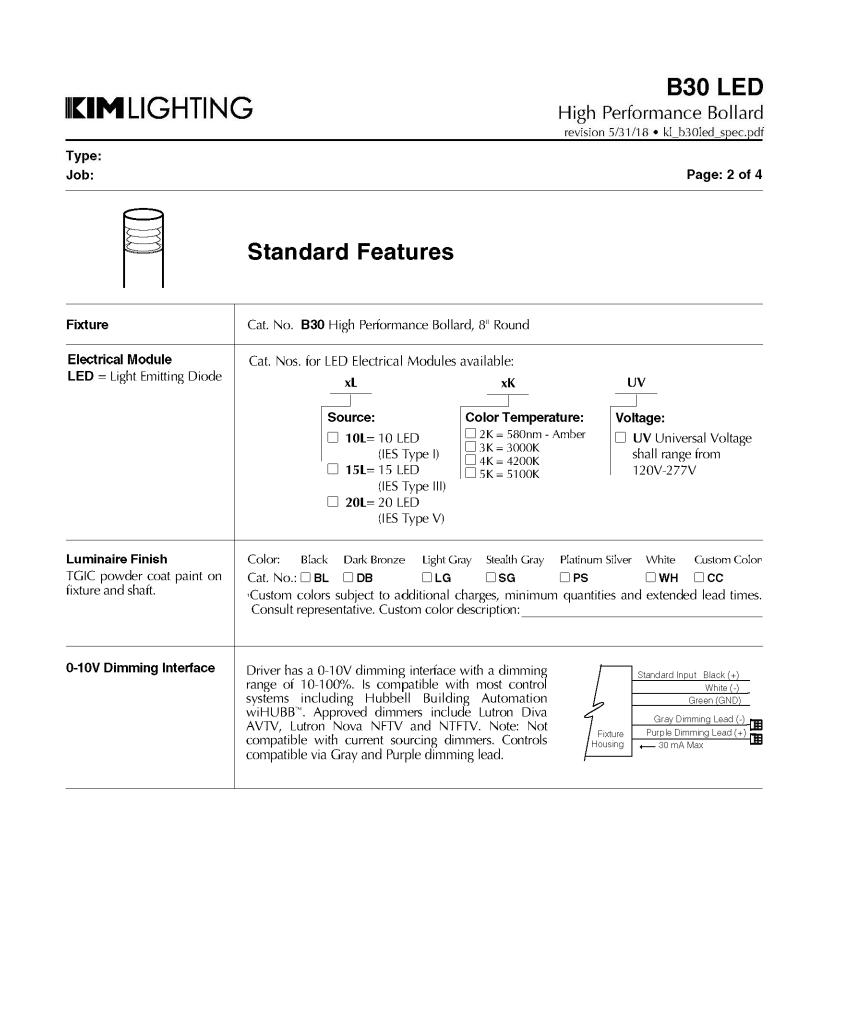

© 2017 KIM LIGHTING • 17760 ROWLAND STREET, CITY OF INDUSTRY, CA 91748 • TEL: 626/968-5666 • FAX: 626/369-2695

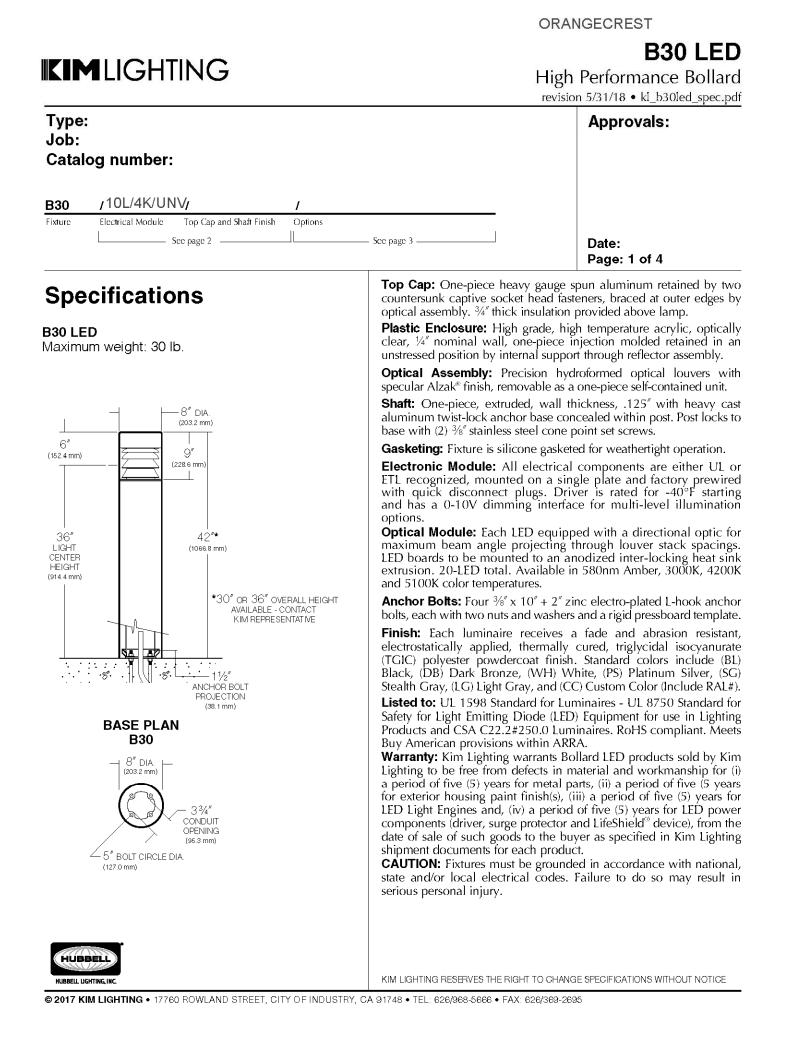

LIGHT FIXTURE TYPE 'B' SCALE NTS

PR-2021-000770 (CUP, DR, GE), Exhibit 7 - Project Plans

25' POLE & BASE DETAIL (TYPE SA1, SB1, SC2 & SC4) | SCALE | NTS

border last saved: Apr/27/2021 10:55 AM by: tmock dwg last saved: Apr/27/2021 10:55 AM by: tmock sheet plotted: Apr/27/2021 @ 10:57 AM drawing file name: f:\20060\site\cad\xref20n6n\xref20n\xref20n6n\xref20n\xr

LONG BEACH, CA. 90807

20060-00-208

PROJECT MANAGER: TRAVUTH MOCK, P.E.

E3 PROJECT NO.:

EMPIRE 3

LINOMIMO